

WRIGHT RESIDENCE ADDITION

1234 RIVERSIDE DR.
ATLANTA GA 30328

MAY 3, 2013

NOTE: CONTRACTOR IS RESPONSIBLE FOR FINAL OUTCOME OF PROJECT. ALL MEASUREMENTS AND CONSTRUCTION DETAILS TO BE FIELD VERIFIED.



DRAWING INDEX

A0.0	COVER
AB.1	EXISTING FLOOR PLAN
A1	PROPOSED FLOOR PLAN
A2	PROPOSED BASEMENT
A3	PROPOSED MAIN FLOOR
A4	PROPOSED ROOF PLAN
A5	ELEVATIONS
A6	PROPOSED DOOR AND WINDOW FRAMING
A7	PLAN DETAILS
A8	PROPOSED FOUNDATION
R1	EXTERIOR RENDERINGS
R2	INTERIOR RENDERINGS

24-HOUR CONTACT


NAME: WILLIAM VERHEY
 ADDRESS: WellSpring Designs
 2445 Kings Point Dr
 Atlanta, GA 30338
 PHONE: 404-502-1201
 EMAIL: William@WellSpringDesigns.org
 WEBSITE: www.WellSpringsDesigns.org

NOT RELEASED FOR CONSTRUCTION

DRAWN BY: WHV
 ~ PHASE ~
 DATE: XX/XX/XXX
 REVISIONS:


 DATE PRINTED: 7/6/2013 @ 1:24:10 PM

WellSpring Designs
 Atlanta, GA 30338
 Office: 404-502-1201
 www.WellSpringDesigns.org
 William@WellSpringDesigns.org

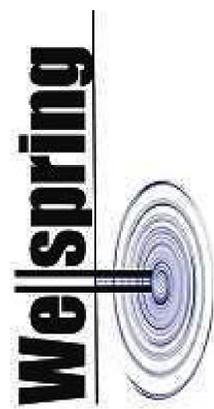

WRIGHT RESIDENCE
 1234 RIVERSIDE DR.
 ATLANTA GA 30328

A0.0
 1 of 13

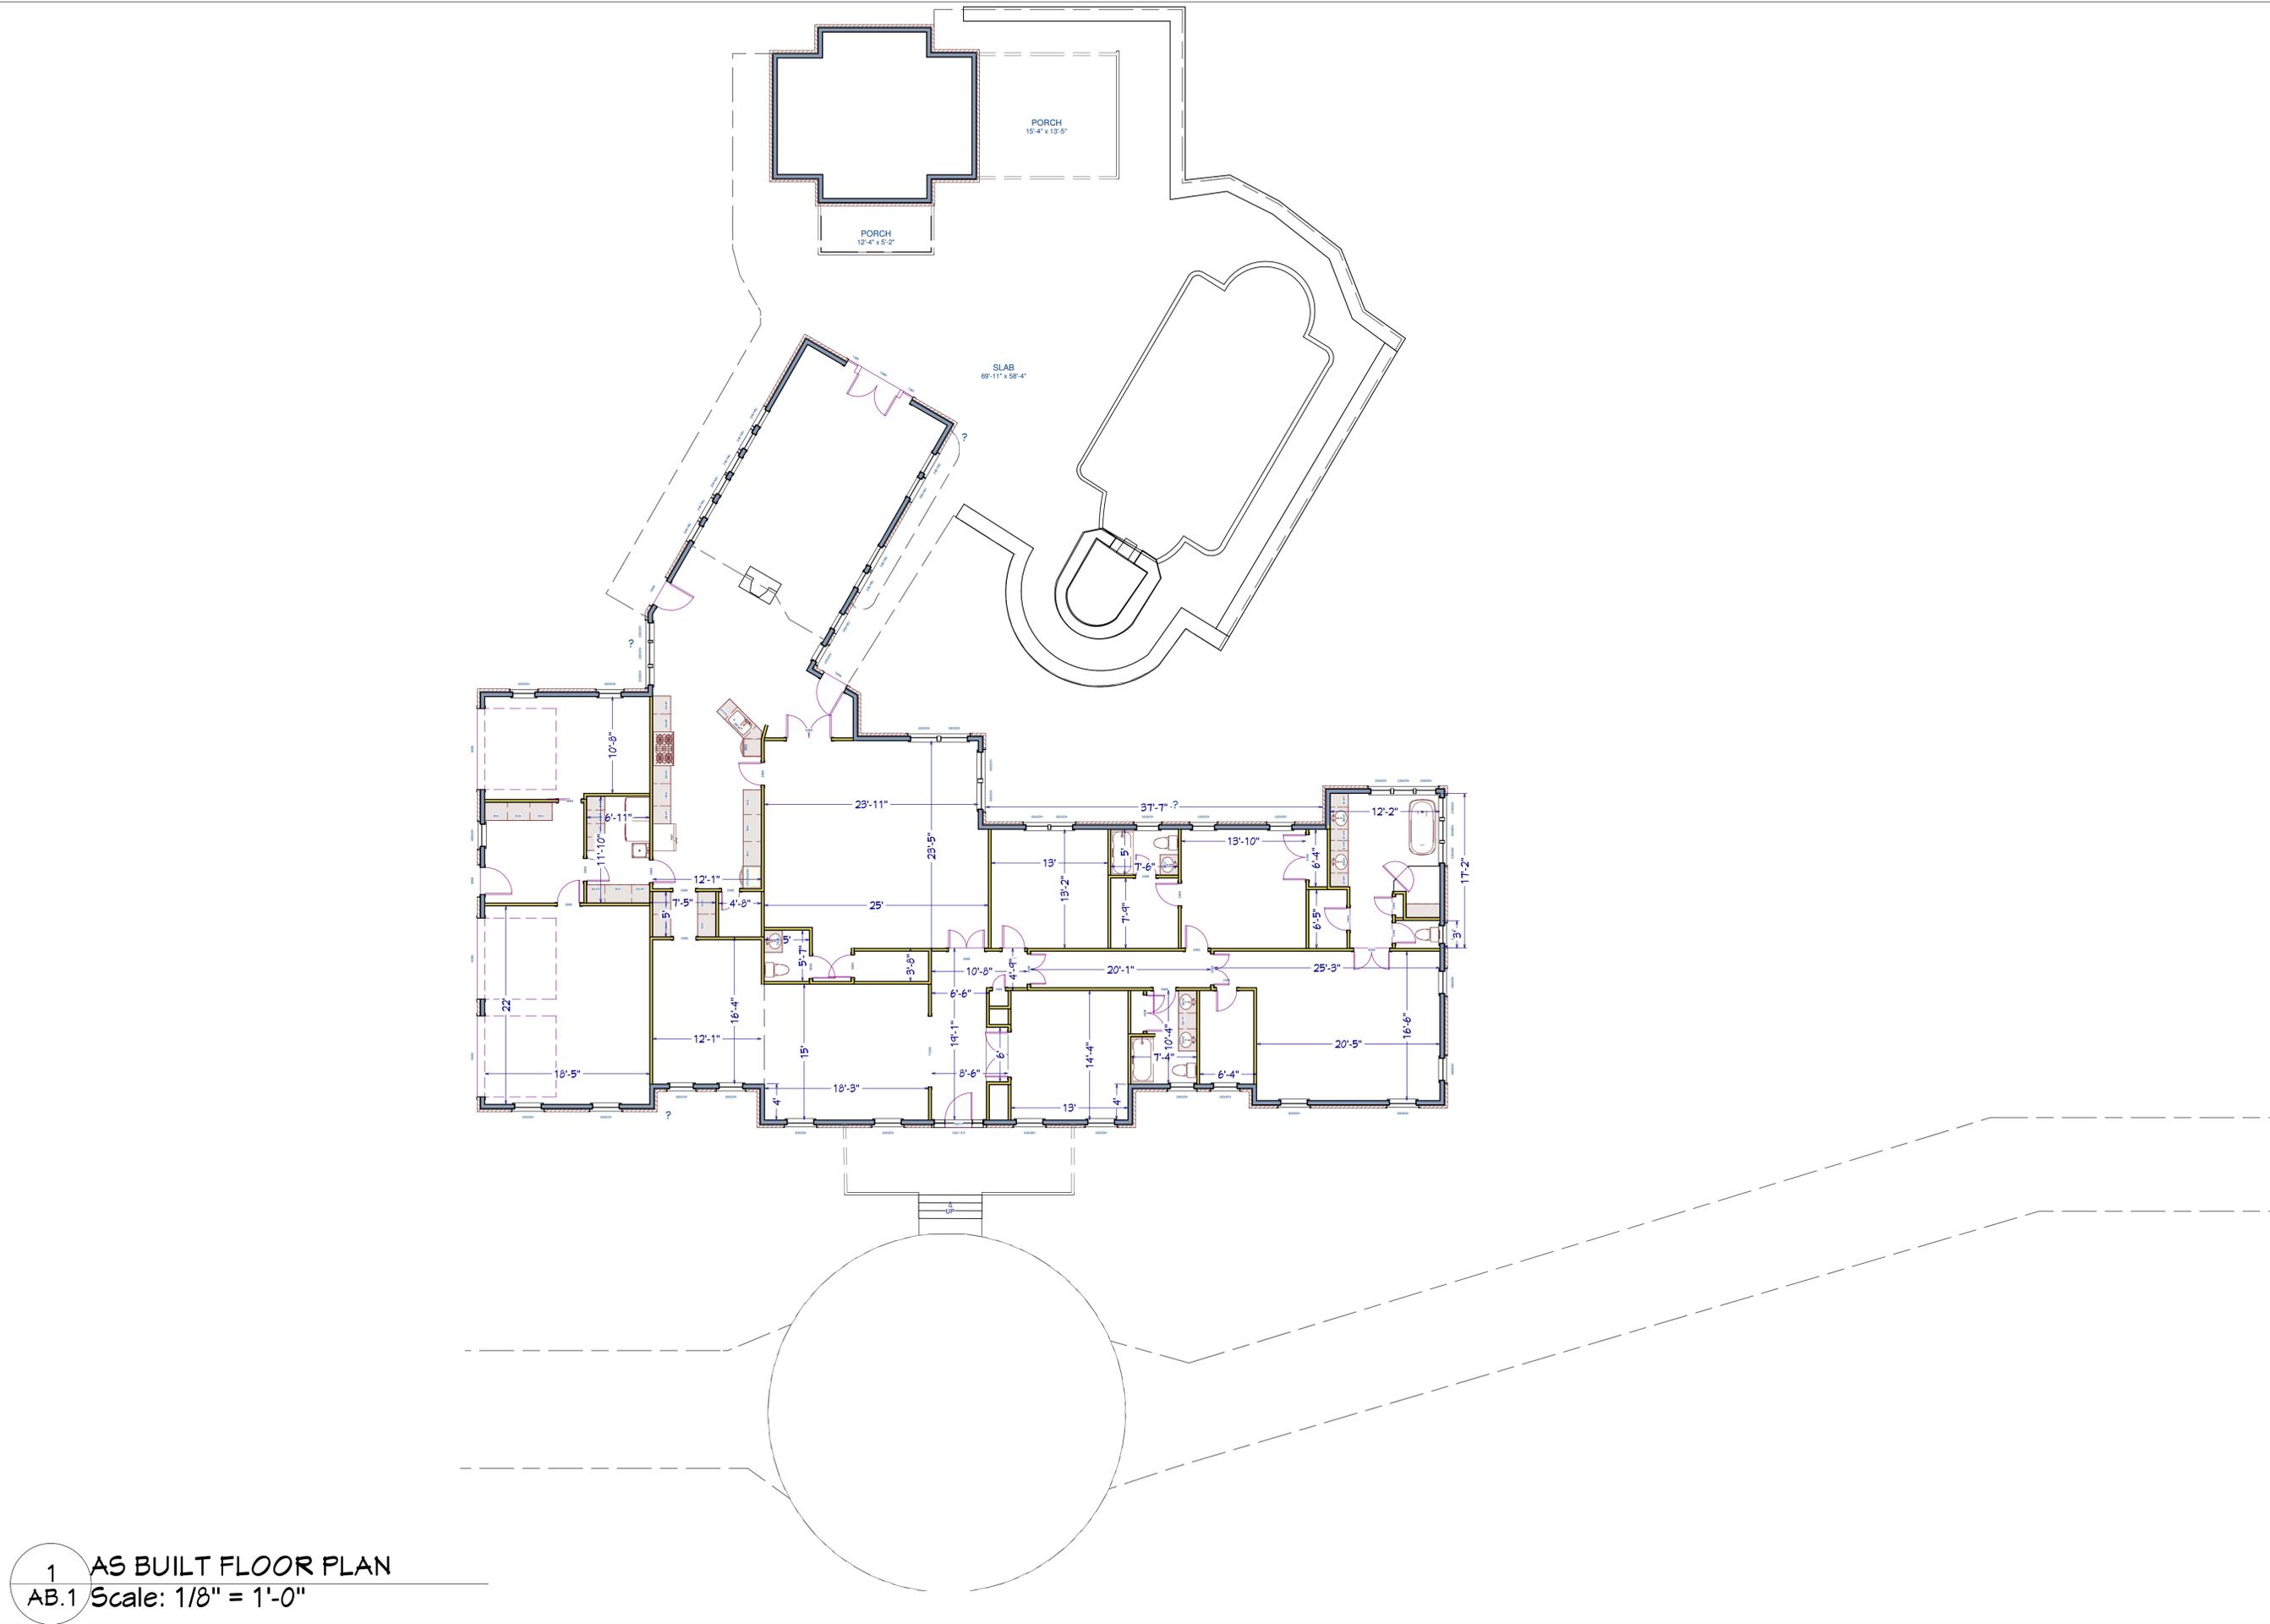

1 AS BUILT FLOOR PLAN
 AB.1 Scale: 1/8" = 1'-0"

NOT RELEASED FOR CONSTRUCTION

DRAWN BY: WHV
 ~ PHASE ~
 DATE:
 XX/XX/XXX
 REVISIONS:
 DATE PRINTED: 7/6/2013 @ 1:24:10 PM


WellSpring Designs
 Atlanta, GA 30338
 Office: 404-502-1201
 www.WellSpringDesigns.org
 William@WellSpringDesigns.org



WRIGHT
 RESIDENCE
 1234 RIVERSIDE DR.
 ATLANTA GA 30328

AB.1
 2 of 13


1 PROPOSED MAIN FLOOR
 A1 Scale: 1/8" = 1'-0"

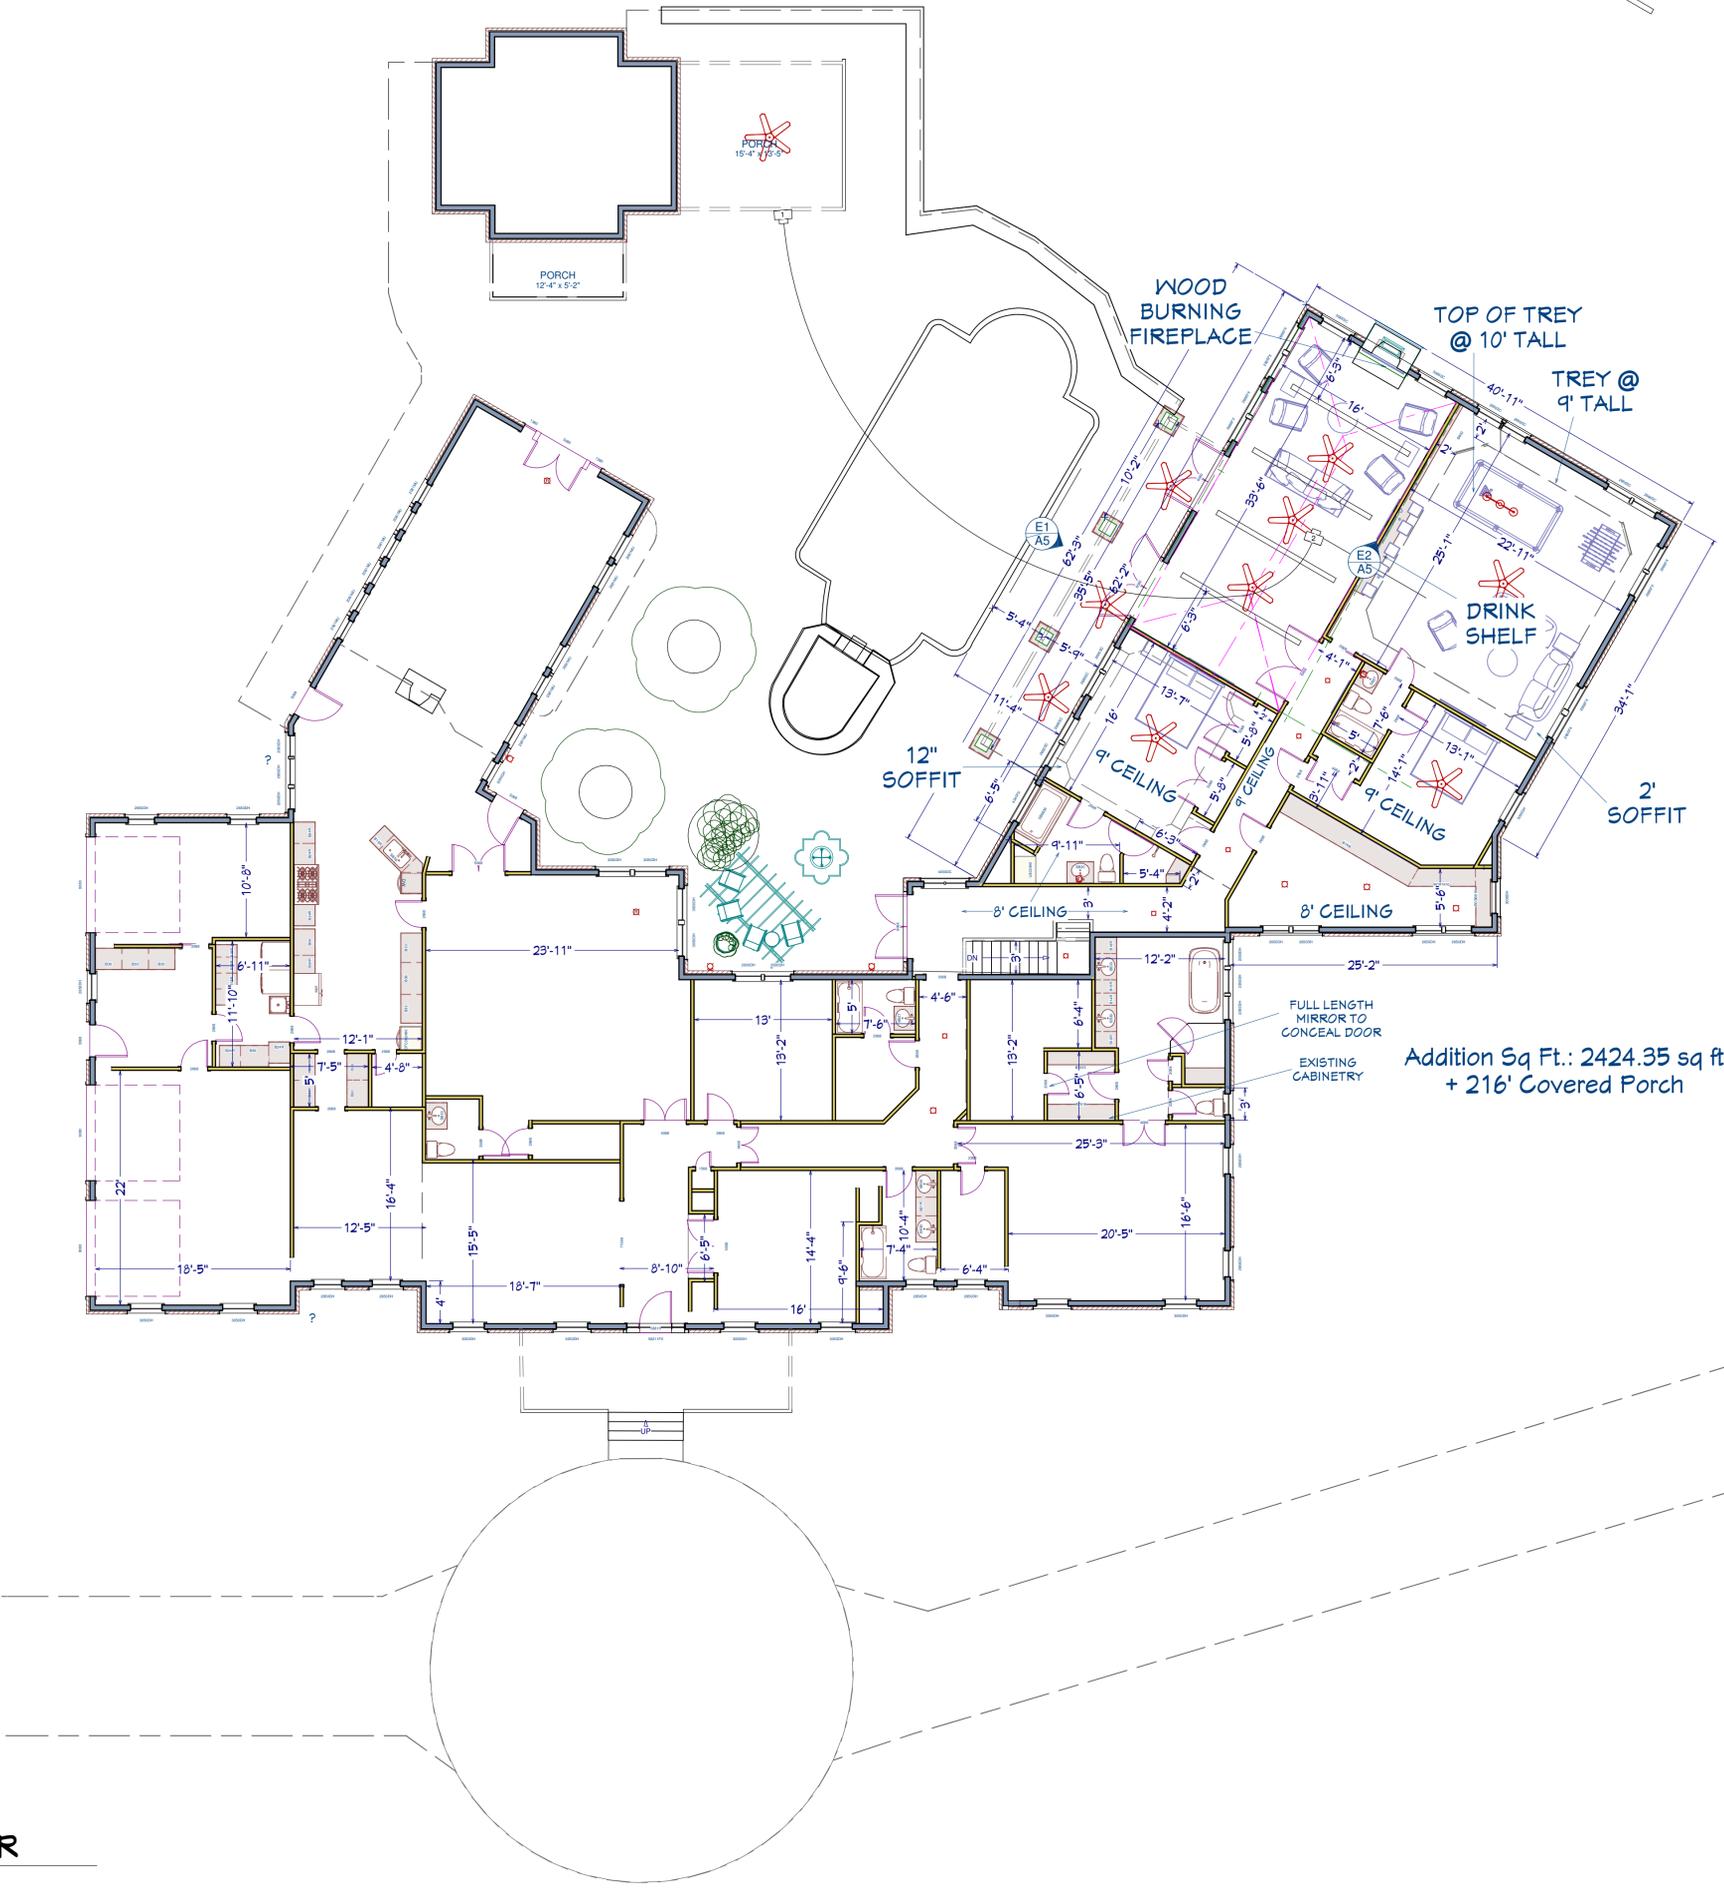

NOT RELEASED FOR CONSTRUCTION


DRAWN BY: WHV
~ PHASE ~
DATE: XX/XX/XXX
REVISIONS:
DATE PRINTED: 7/6/2013 @ 1:24:12 PM

WellSpring Designs
 Atlanta, GA 30338
 Office: 404-502-1201
 www.WellSpringDesigns.org
 William@WellSpringDesigns.org

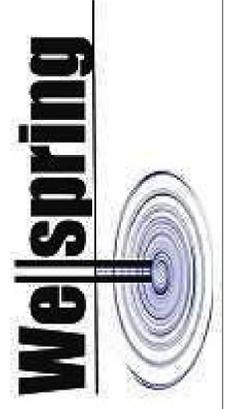

WRIGHT
 RESIDENCE
 1234 RIVERSIDE DR.
 ATLANTA GA 30328

A1
 3 of 13

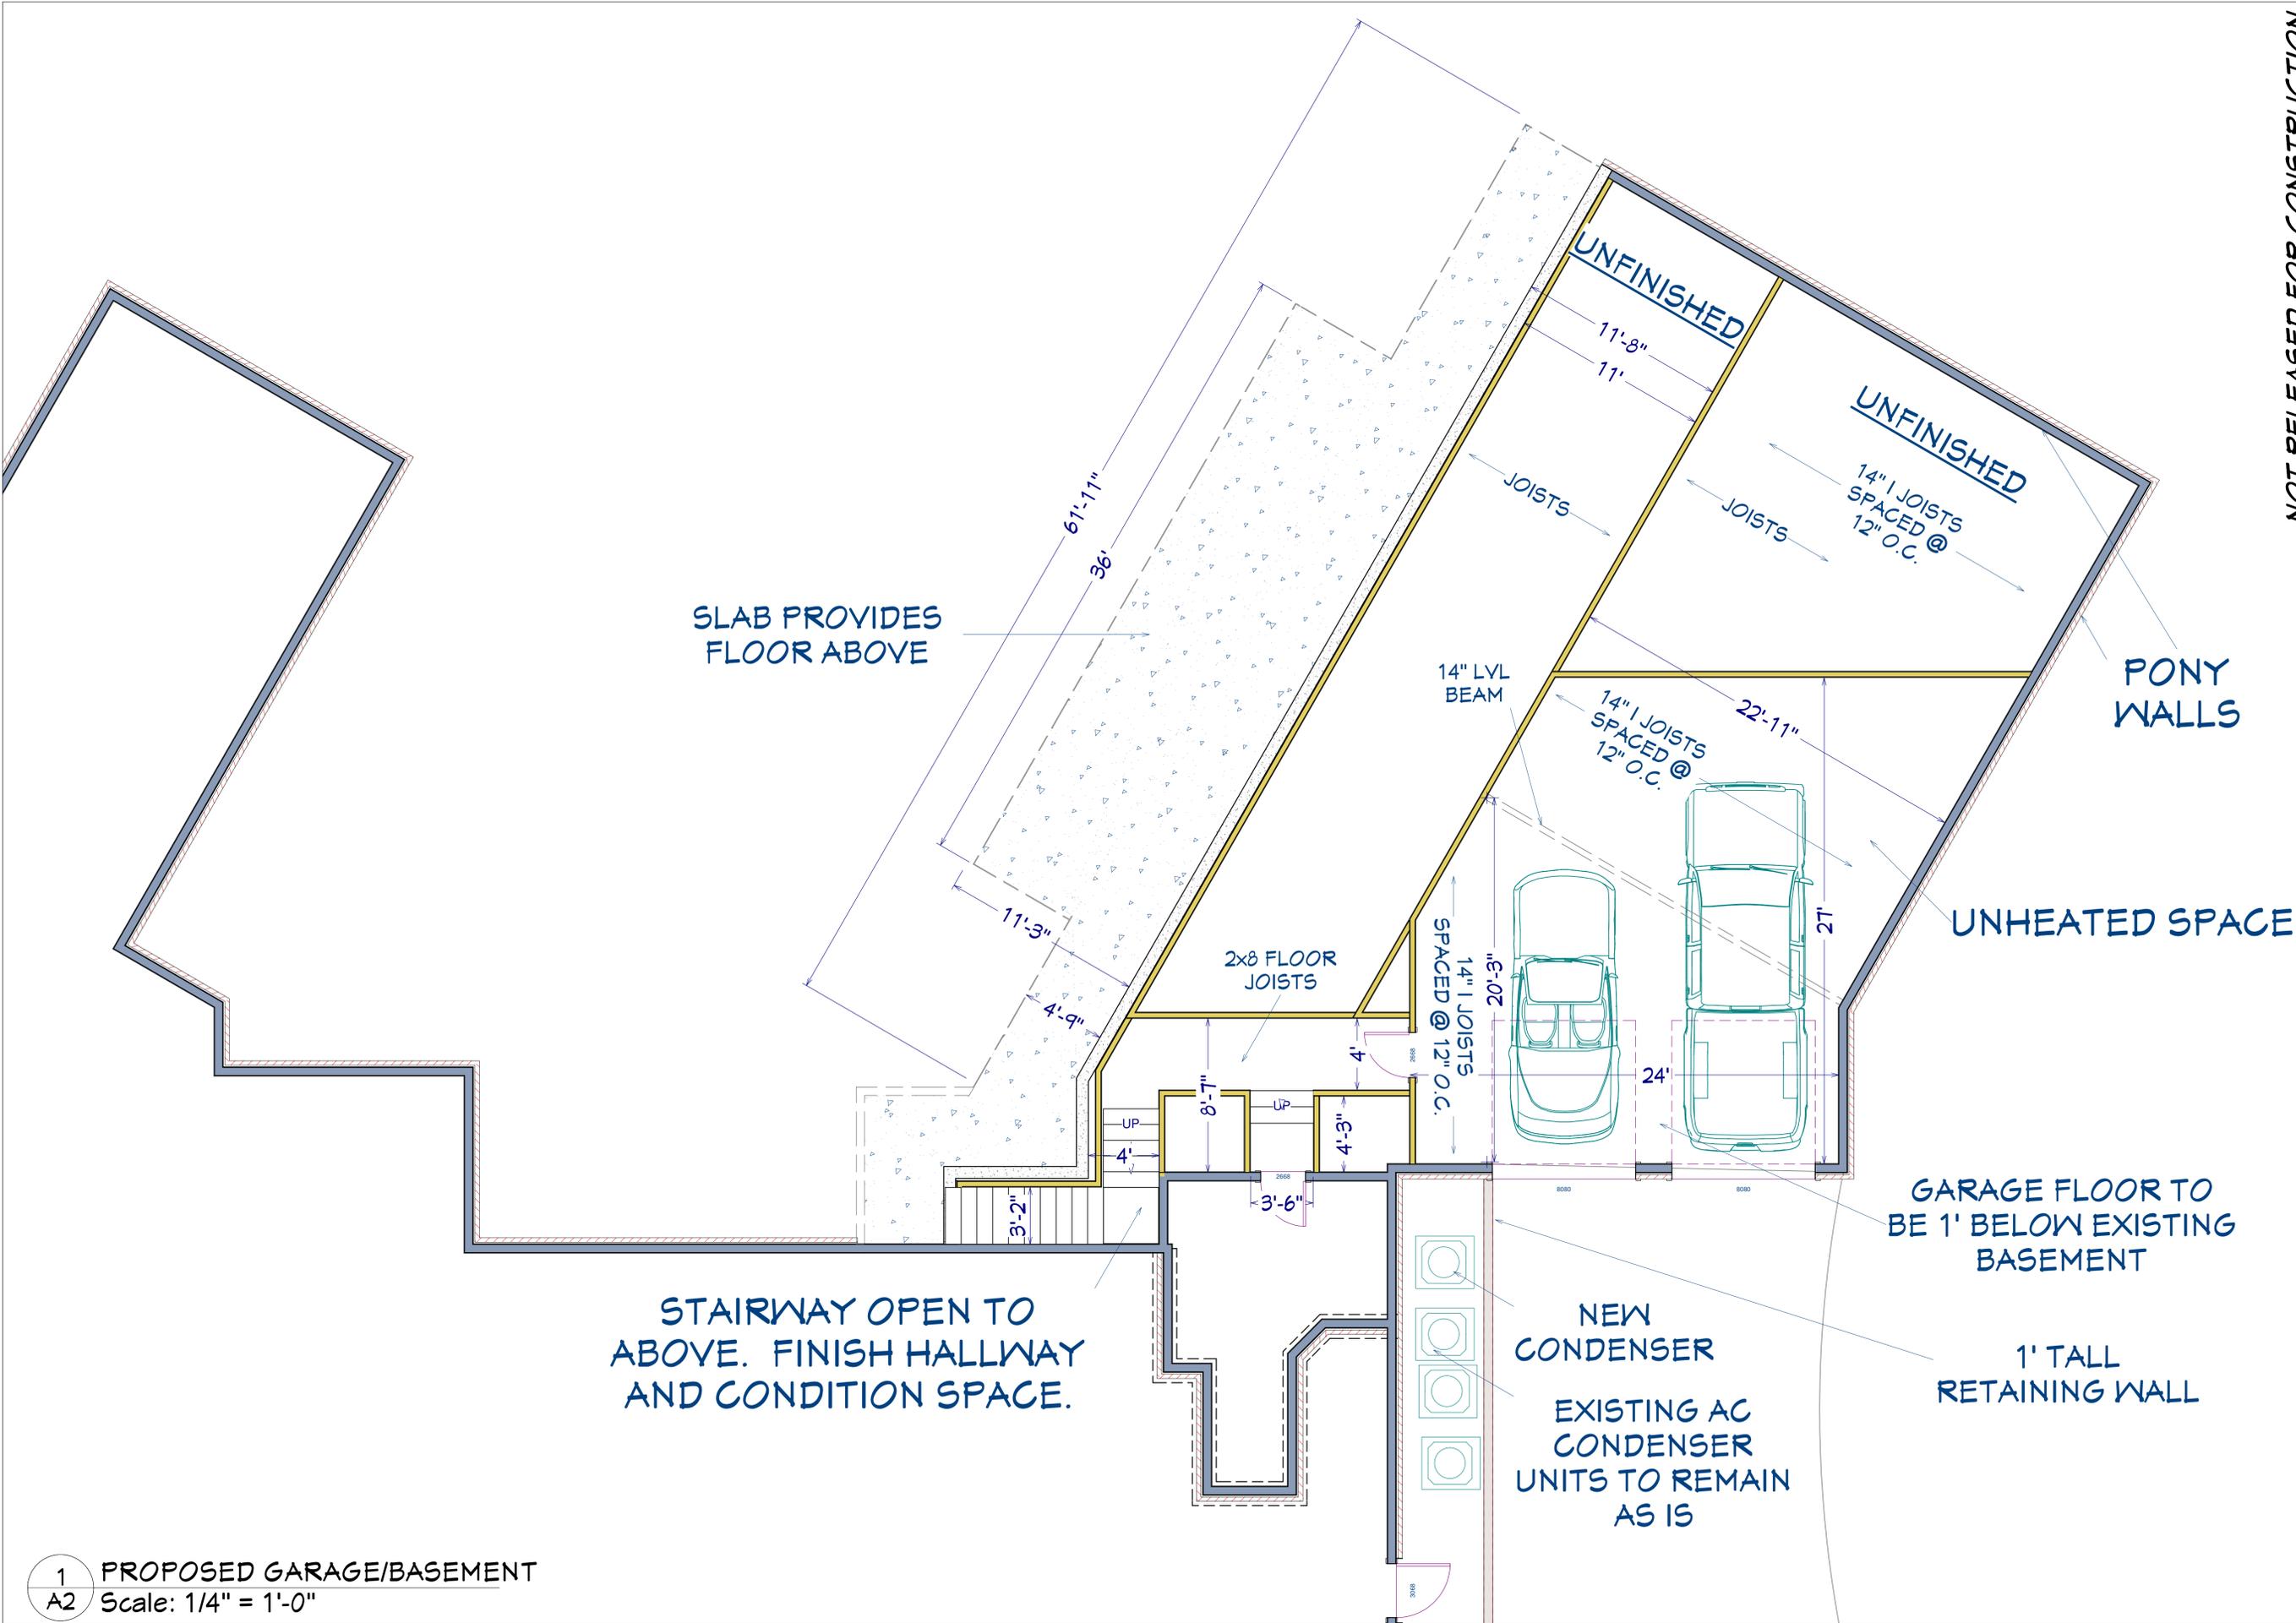

1 PROPOSED GARAGE/BASEMENT
 A2 Scale: 1/4" = 1'-0"

NOT RELEASED FOR CONSTRUCTION


DRAWN BY: WHV
~ PHASE ~
DATE: XX/XX/XXX
REVISIONS:
DATE PRINTED: 7/6/2013 @ 1:24:12 PM

WellSpring Designs
 Atlanta, GA 30338
 Office: 404-502-1201
 www.WellSpringDesigns.org
 William@WellSpringDesigns.org



WRIGHT RESIDENCE
 1234 RIVERSIDE DR.
 ATLANTA GA 30328

A2 4 of 13

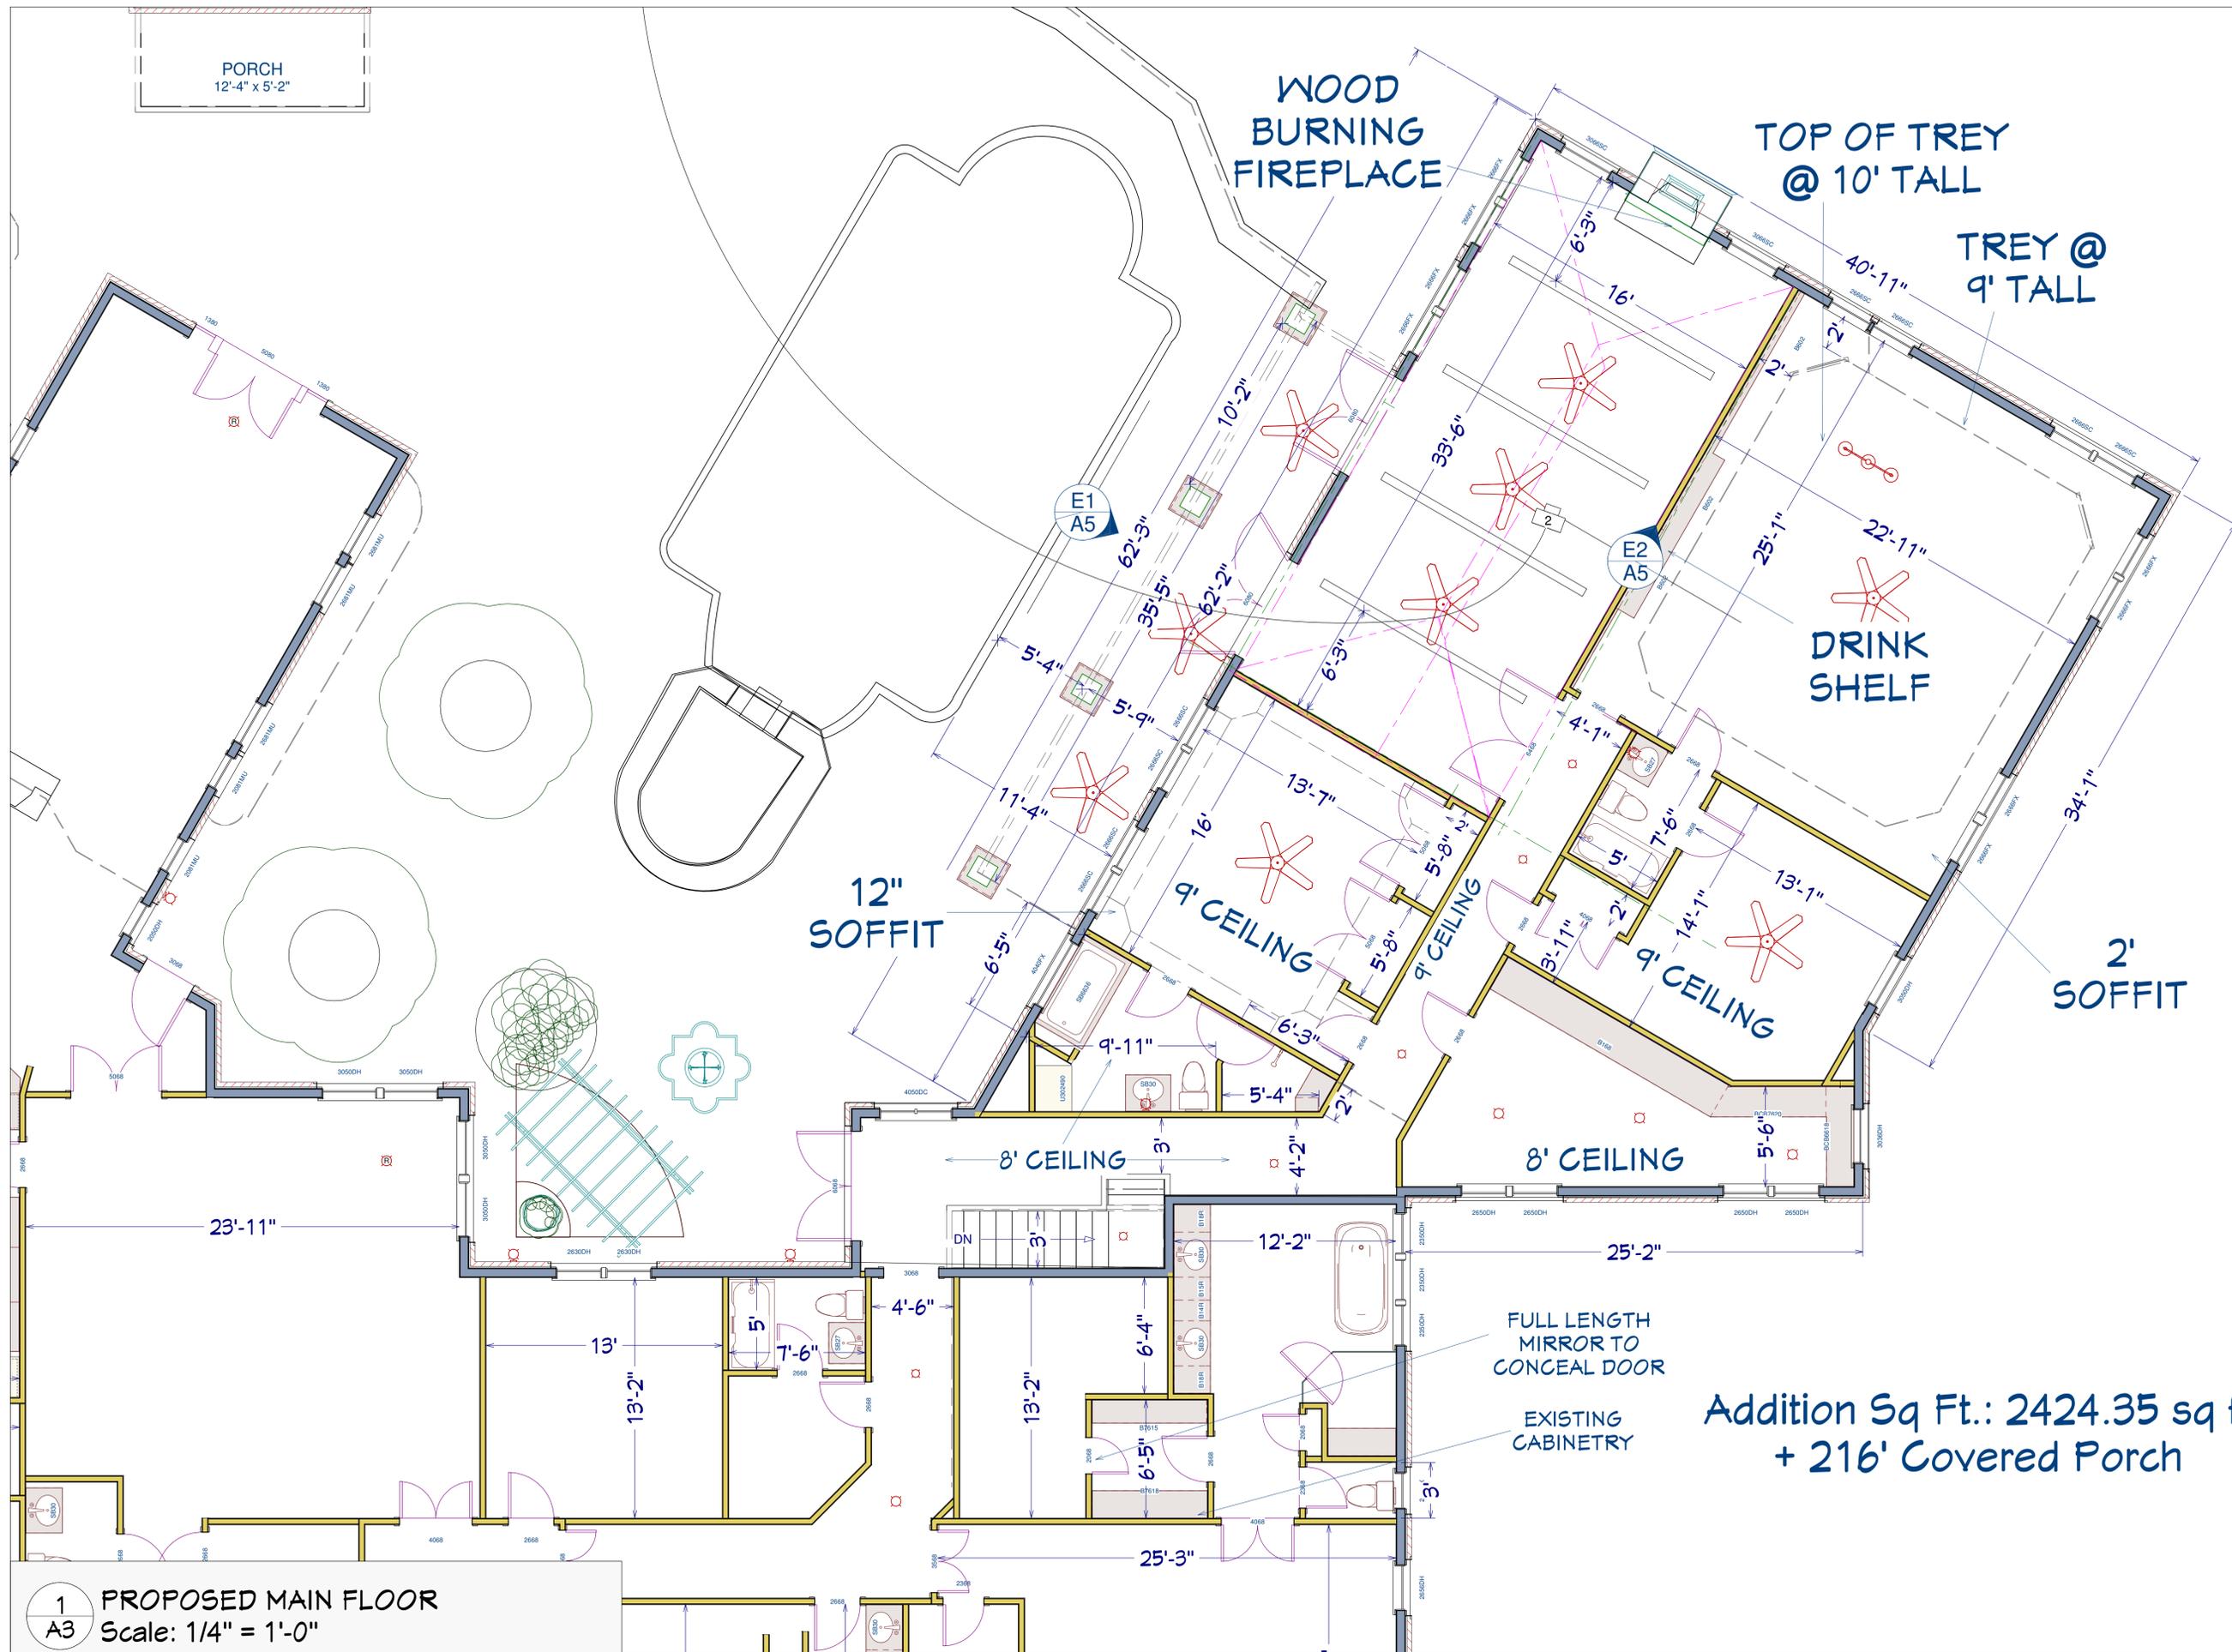

1 PROPOSED MAIN FLOOR
 A3 Scale: 1/4" = 1'-0"

Addition Sq Ft.: 2424.35 sq ft
 + 216' Covered Porch

NOT RELEASED FOR CONSTRUCTION


DRAWN BY: WHV
 ~ PHASE ~
 DATE: XX/XX/XX
 REVISIONS:
 DATE PRINTED: 7/6/2013 @ 1:24:13 PM

WellSpring Designs
 Atlanta, GA 30338
 Office: 404-502-1201
 www.WellSpringDesigns.org
 William@WellSpringDesigns.org



WRIGHT RESIDENCE
 1234 RIVERSIDE DR.
 ATLANTA GA 30328

A3 5 of 13

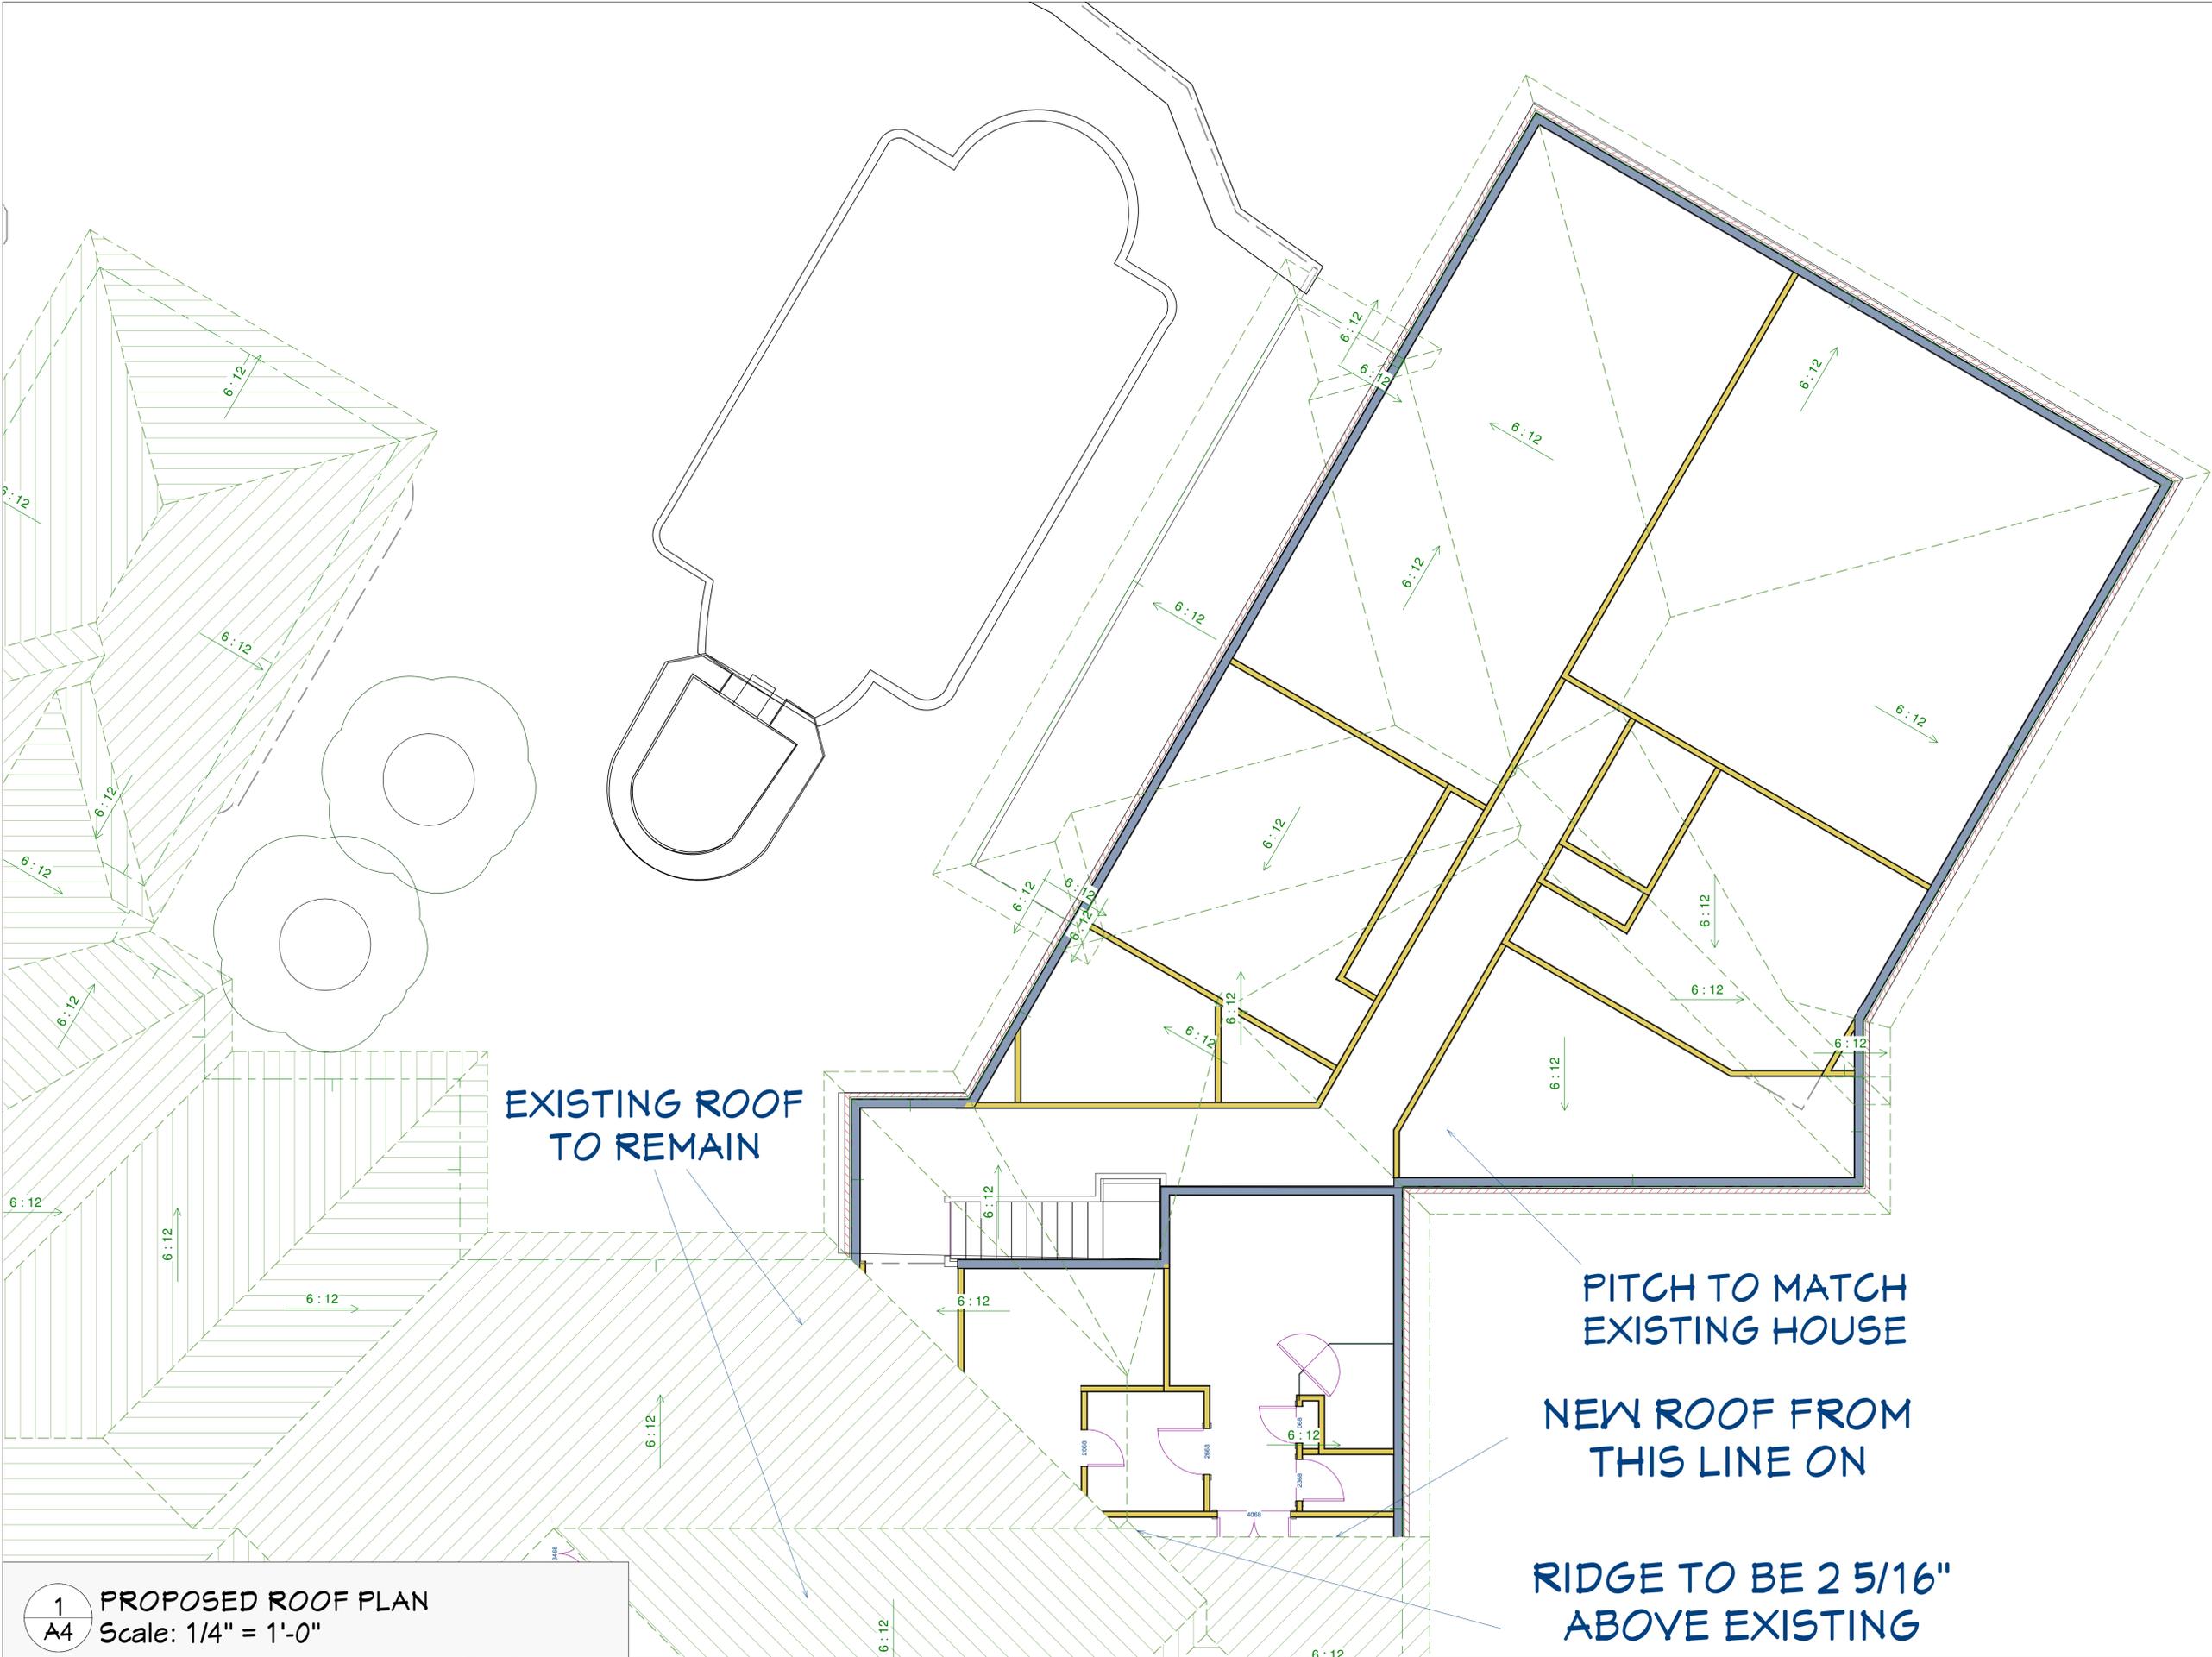

1 PROPOSED ROOF PLAN
 A4 Scale: 1/4" = 1'-0"


NOT RELEASED FOR CONSTRUCTION

DRAWN BY: WHV
~ PHASE ~
DATE: XX/XX/XXX
REVISIONS:
DATE PRINTED: 7/6/2013 @ 1:24:13 PM

WellSpring Designs
 Atlanta, GA 30338
 Office: 404-502-1201
 www.WellSpringDesigns.org
 William@WellSpringDesigns.org




WRIGHT
 RESIDENCE
 1234 RIVERSIDE DR.
 ATLANTA GA 30328

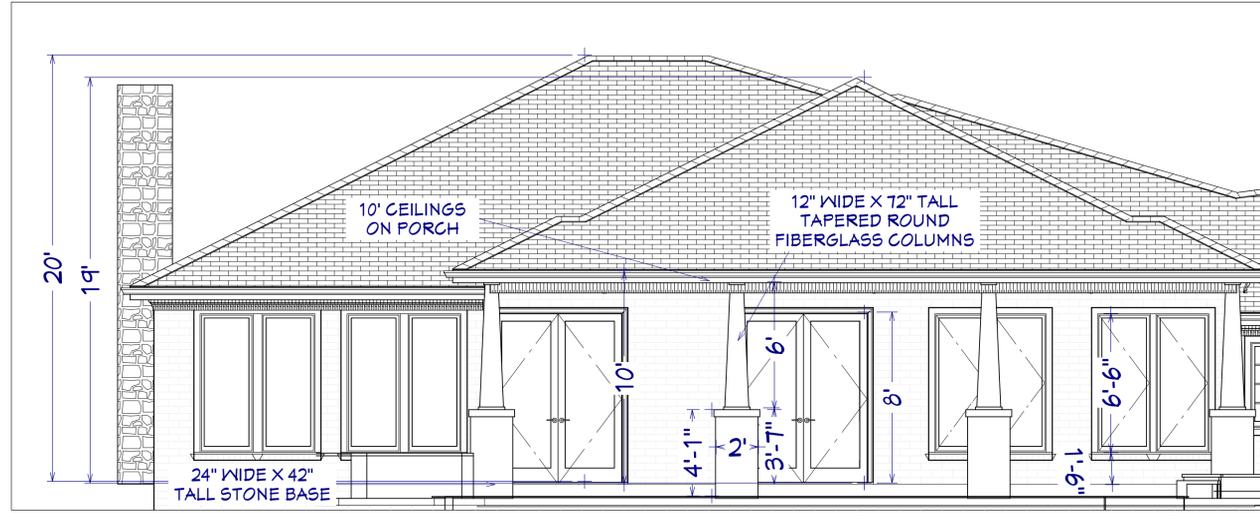

ELEVATION 1

E1
A5

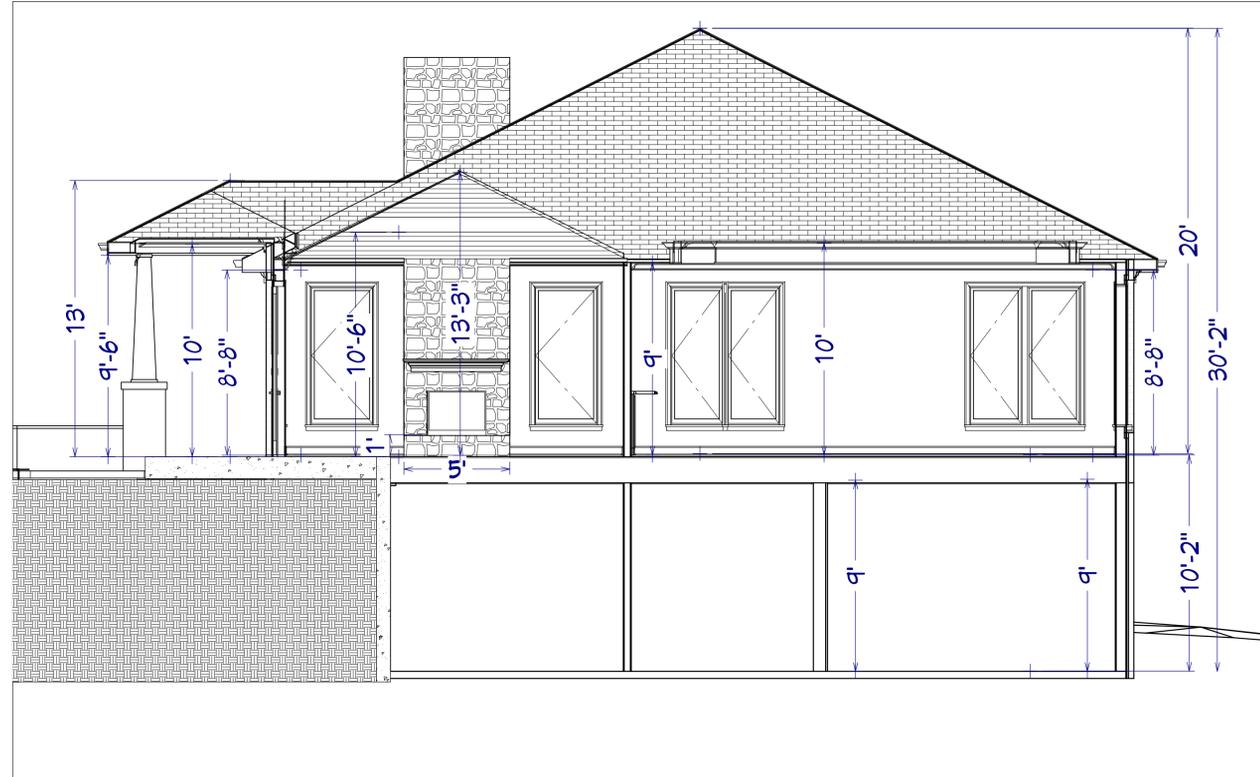


ELEVATION 2

E2
A5


NOT RELEASED FOR CONSTRUCTION

DRAWN BY: WHV
~ PHASE ~
DATE: XX/XX/XXX
REVISIONS:
DATE PRINTED: 7/6/2013 @ 1:24:13 PM

WellSpring Designs
Atlanta, GA 30338
Office: 404-502-1201
www.WellSpringDesigns.org
William@WellSpringDesigns.org

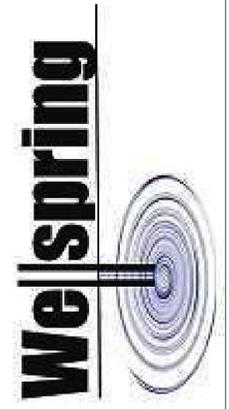

WRIGHT
RESIDENCE
1234 RIVERSIDE DR.
ATLANTA GA 30328

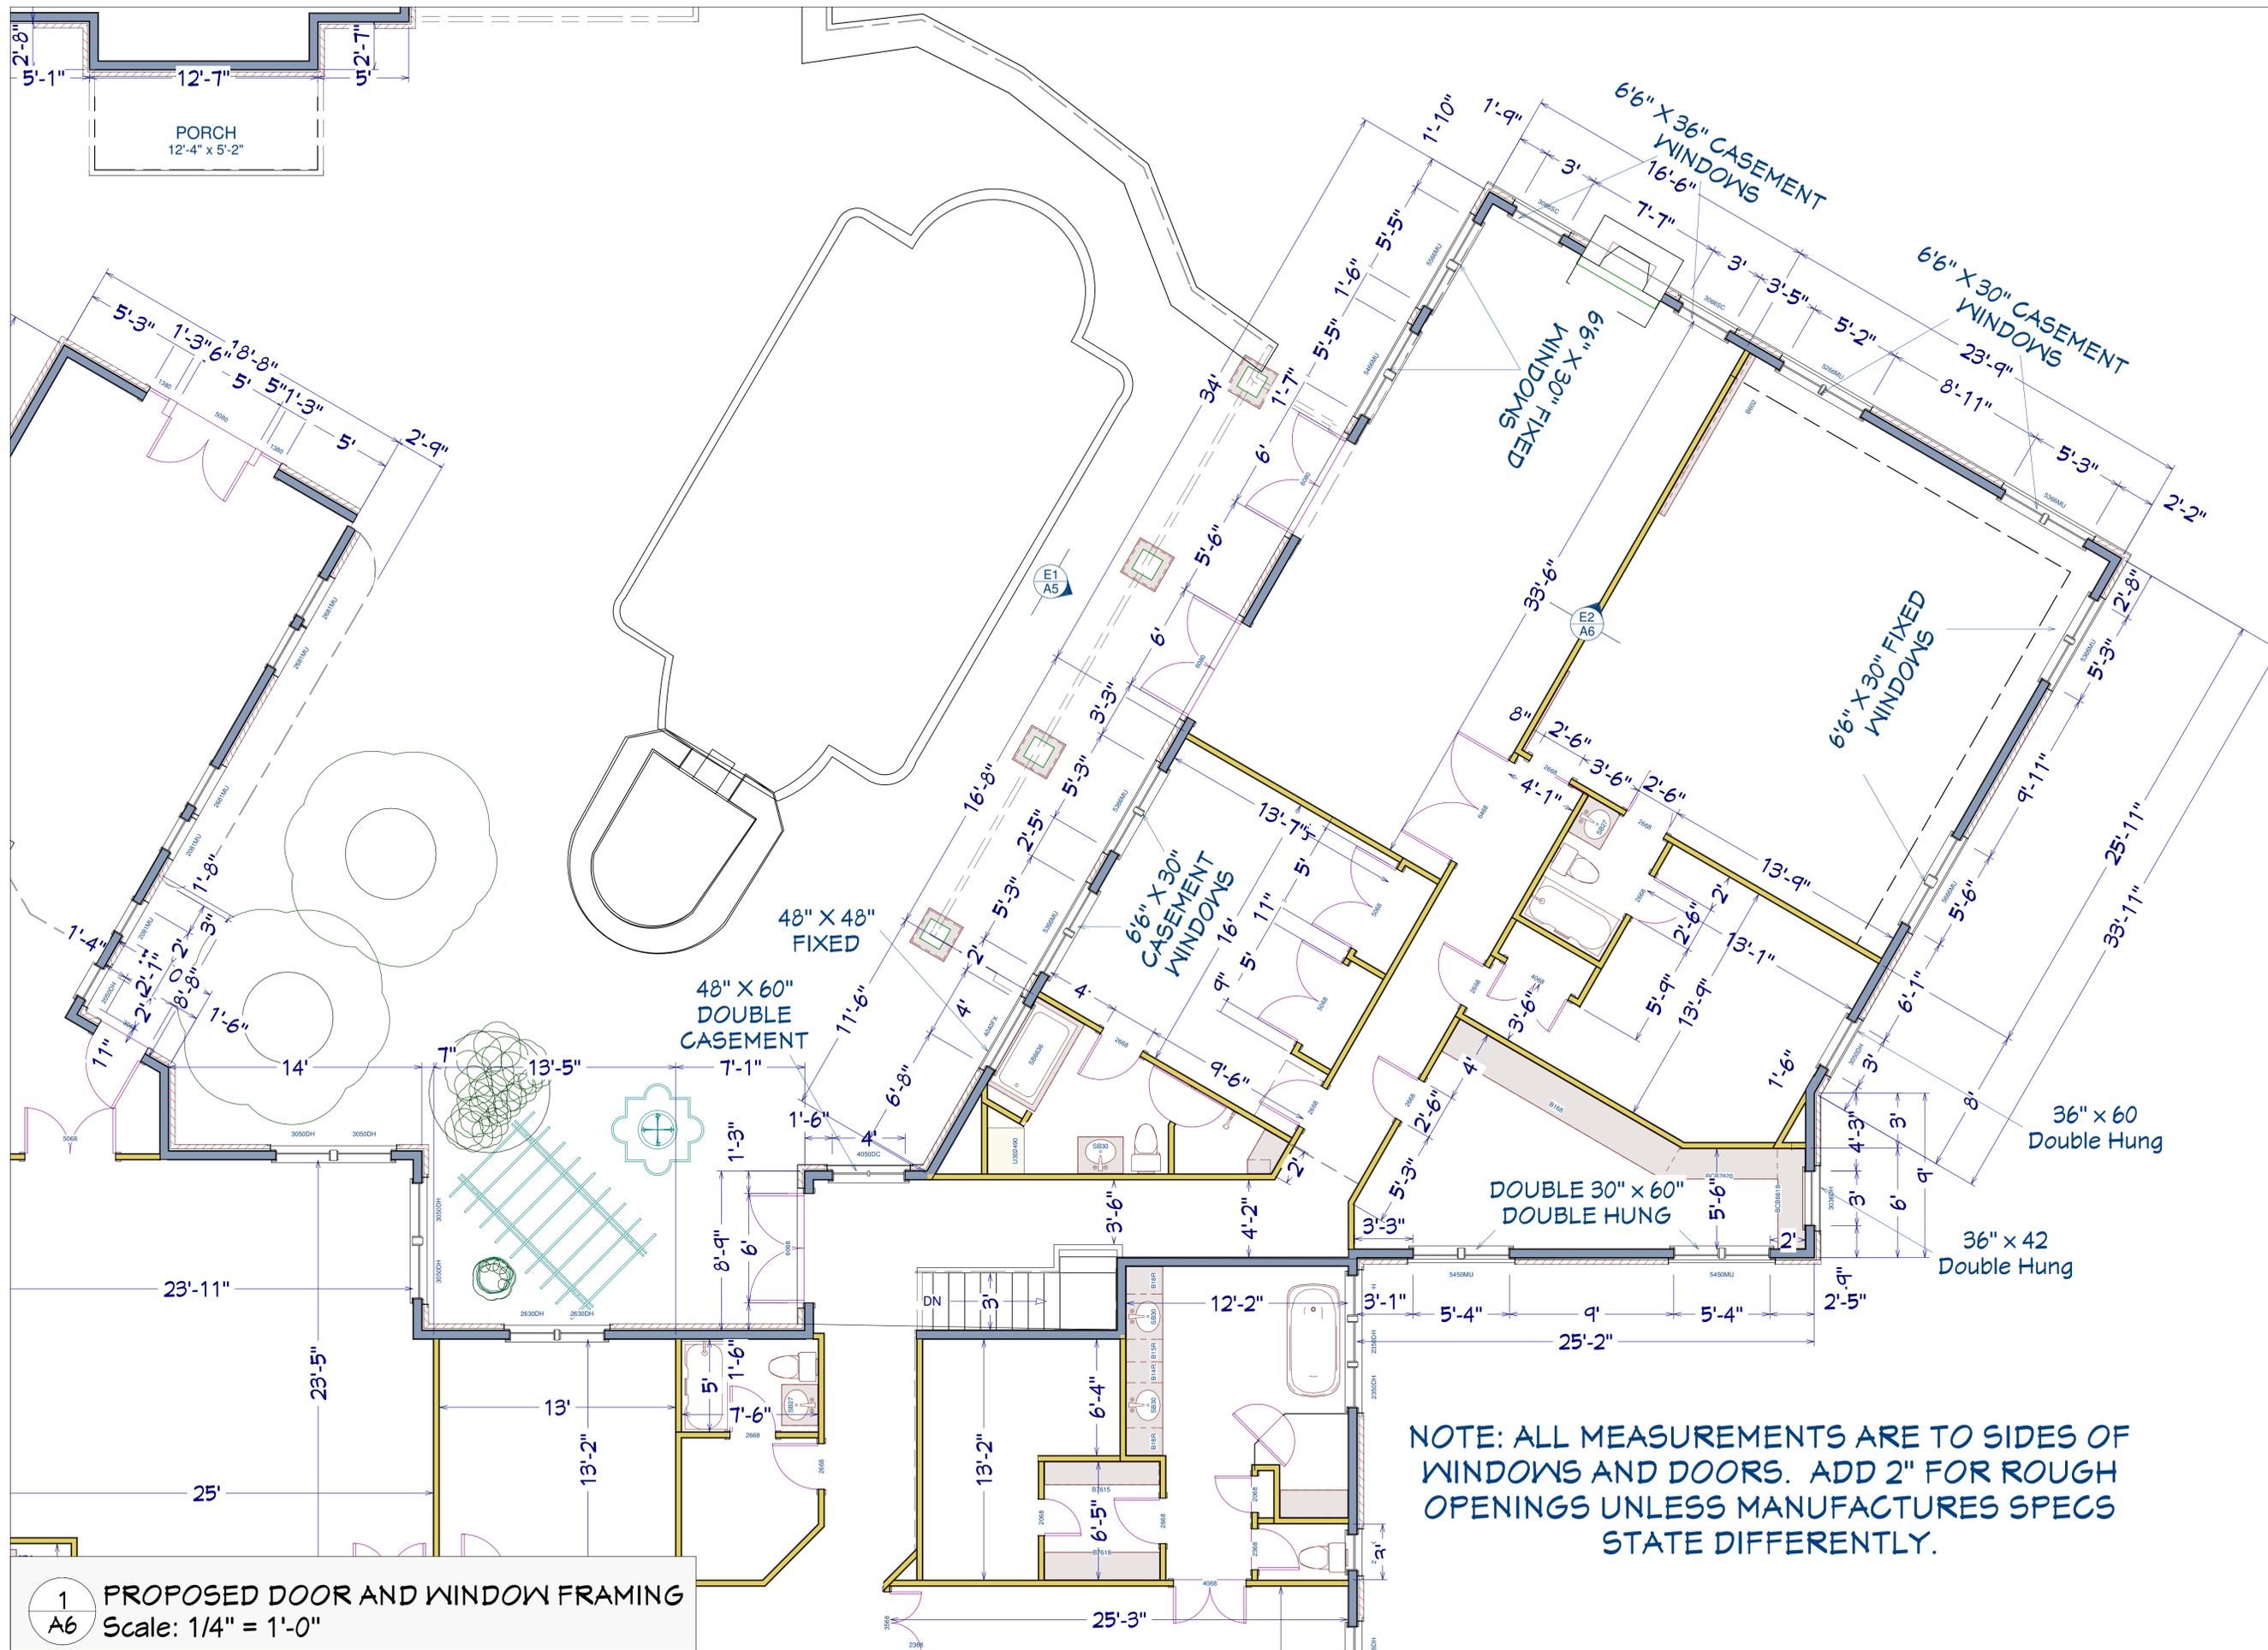

1 PROPOSED DOOR AND WINDOW FRAMING
 A6 Scale: 1/4" = 1'-0"

NOTE: ALL MEASUREMENTS ARE TO SIDES OF WINDOWS AND DOORS. ADD 2" FOR ROUGH OPENINGS UNLESS MANUFACTURERS SPECS STATE DIFFERENTLY.

NOT RELEASED FOR CONSTRUCTION

DRAWN BY:	WHV
~ PHASE ~	
DATE:	XX/XX/XXX
REVISIONS:	
DATE PRINTED:	1/6/2013 @ 1:24:13 PM


WellSpring Designs
 Atlanta, GA 30338
 Office: 404-502-1201
 www.WellSpringDesigns.org
 William@WellSpringDesigns.org




WRIGHT RESIDENCE
 1234 RIVERSIDE DR.
 ATLANTA GA 30328

PLAN NOTES:

- 1: #1 COMMON OAK HARDWOODS THROUGHOUT ADDITION, EXCEPT BATHROOMS
- 2: ALL NEW WINDOWS TO BE PELLA PRO LINE 450 WITH PAINTED INTERIOR
- 3: ALL PLUMBING FIXTURES TO BE KOHLER BRAND FROM THE DEVONSHIRE COLLECTION
- 4: STANDARD PAINT GRADE BASE BOARD, CROWN AND CASING TO MATCH EXISTING
5. ALL INTERIOR DOORS TO BE PAINT GRADE SOLID PINE
6. ALL EXTERIOR DOORS TO BE PELLA PRO LINE 450 WITH PAINTED INTERIOR
7. WOOD BURNING FIREPLACE WITH GAS IGNITION.
8. BEAD BOARD WAINSCOTING IN PORCH WITH PAINTED CHAIR RAIL
9. BAR SEATING AND DRINK SHELF IN GAME ROOM TO BE GRANITE WITH PAINTED PANELING UNDERNEATH

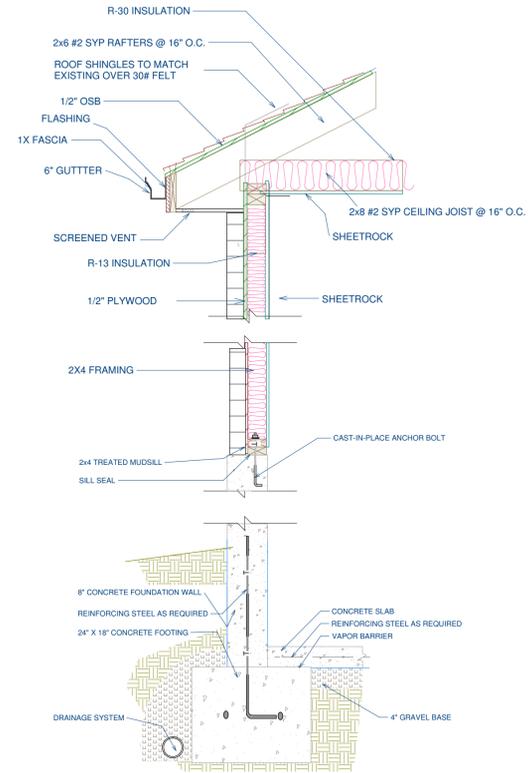

WALL DETAIL

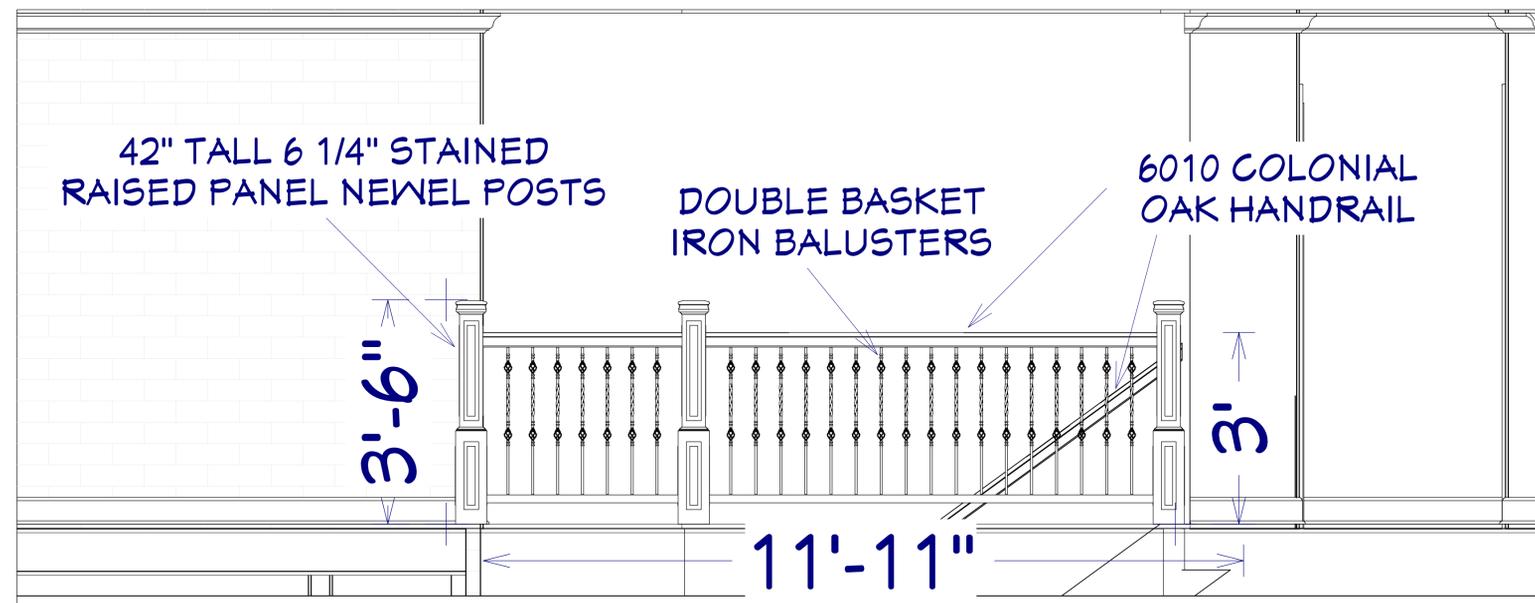

STAIR RAIL DETAIL


NOT RELEASED FOR CONSTRUCTION

DRAWN BY: WHV
~ PHASE ~
DATE: XX/XX/XXX
REVISIONS:
DATE PRINTED: 7/6/2013 @ 1:24:14 PM

WellSpring Designs
Atlanta, GA 30338
Office: 404-502-1201
www.WellSpringDesigns.org
William@WellSpringDesigns.org



WRIGHT
RESIDENCE
1234 RIVERSIDE DR.
ATLANTA GA 30328

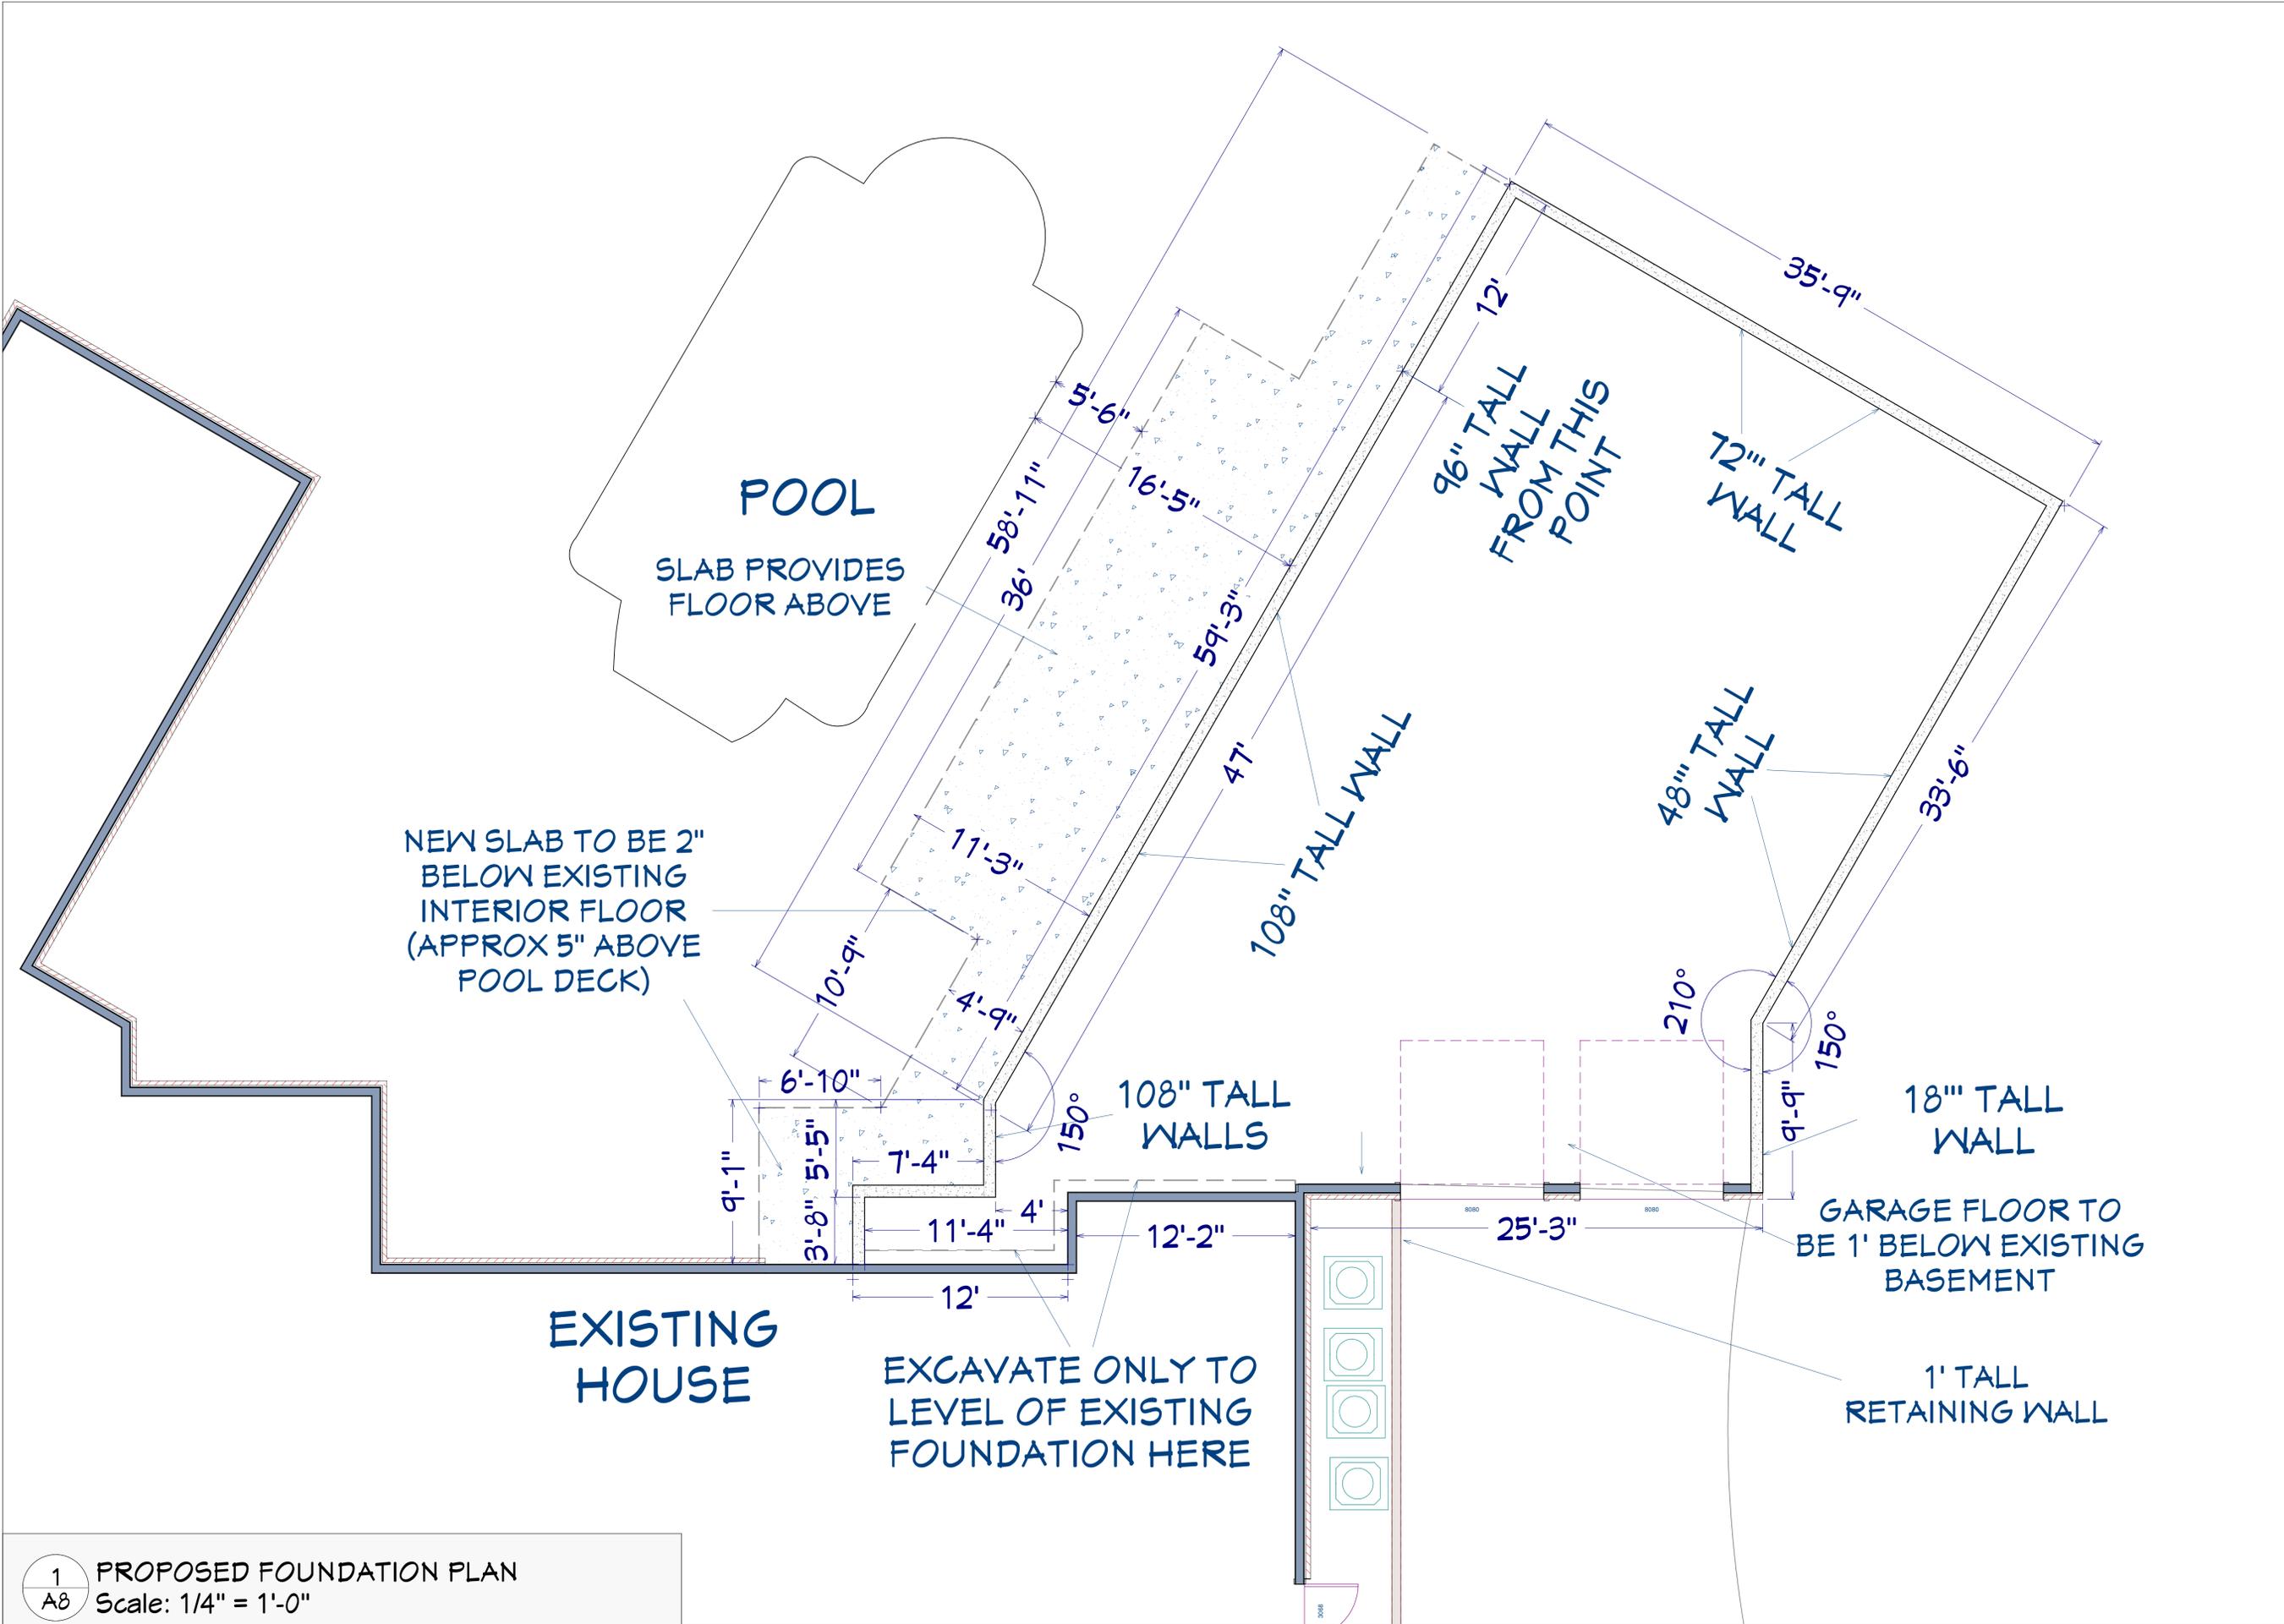

1 PROPOSED FOUNDATION PLAN
 A8 Scale: 1/4" = 1'-0"

NOT RELEASED FOR CONSTRUCTION

DRAWN BY: WHV
 ~ PHASE ~
 DATE: XX/XX/XXX
 REVISIONS:

DATE PRINTED: 7/6/2013 @ 1:24:14 PM

WellSpring Designs
 Atlanta, GA 30338
 Office: 404-502-1201
 www.WellSpringDesigns.org
 William@WellSpringDesigns.org



WRIGHT RESIDENCE
 1234 RIVERSIDE DR.
 ATLANTA GA 30328

A8 10 of 13



RENDER 1



RENDER 2



RENDER 3



RENDER 4

NOT RELEASED FOR CONSTRUCTION

DRAWN BY: WHV
 ~ PHASE ~
 DATE: XX/XX/XXX
 REVISIONS:
 DATE PRINTED: 7/6/2013 @ 1:24:14 PM

WellSpring Designs
 Atlanta, GA 30338
 Office: 404-502-1201
 www.WellSpringDesigns.org
 William@WellSpringDesigns.org



WRIGHT
 RESIDENCE
 1234 RIVERSIDE DR.
 ATLANTA GA 30328

R1
 11 of 13



PORCH RENDER 1



PORCH RENDER 2



GAME ROOM 1




GAME ROOM 2

NOT RELEASED FOR CONSTRUCTION

DRAWN BY: WHV
~ PHASE ~
DATE: XX/XX/XXX
REVISIONS:
DATE PRINTED: 7/6/2013 @ 1:24:15 PM

WellSpring Designs
Atlanta, GA 30338
Office: 404-502-1201
www.WellSpringDesigns.org
William@WellSpringDesigns.org

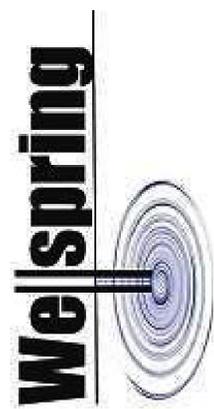

WRIGHT
RESIDENCE
1234 RIVERSIDE DR.
ATLANTA GA 30328



GAME ROOM 3




STAIRWAY

NOT RELEASED FOR CONSTRUCTION

DRAWN BY: WHV
~ PHASE ~
DATE: XX/XX/XXX
REVISIONS:

DATE PRINTED: 7/6/2013 @ 1:24:15 PM

WellSpring Designs
Atlanta, GA 30338
Office: 404-502-1201
www.WellSpringDesigns.org
William@WellSpringDesigns.org

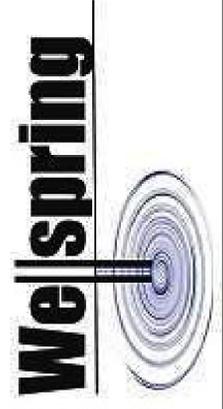

WRIGHT
RESIDENCE
1234 RIVERSIDE DR.
ATLANTA GA 30328